
GREG TUZZOLO, CHAIR

ANDREW D'AMOUR, VICE CHAIR

JIM COLEMAN



CHRIS ARSENAULT

BILL CRANSHAW


APPROVAL DATE

ENDORSEMENT DATE

TYPE	MANUFACTURER	CATALOGUE #	LAMPING			MOUNTING	REMARKS
			TYPE	WATTAGE	QUANTITY		
AA	MCGRAW EDISON	GLEON-AF-01-LED-E1-SL4-HSS	LED	59W		POLE	
AA(POLE)							12'-0" POLE MOUNTED ON 2'-0" CONCRETE BASE
BB	MCGRAW EDISON	ISC-E01-LED-E1-BL4	LED			WALL	WALL PACK MOUNTED @ 14'-0" AFG
CC	MCGRAW EDISON	ISC-E02-LED-E1-BL4	LED	46.9W		WALL	WALL PACK MOUNTED @ 14'-0" AFG
DD	MCGRAW EDISON	ISC-E02-LED-E1-SLL	LED	46.9W		WALL	WALL PACK MOUNTED @ 14'-0" AFG

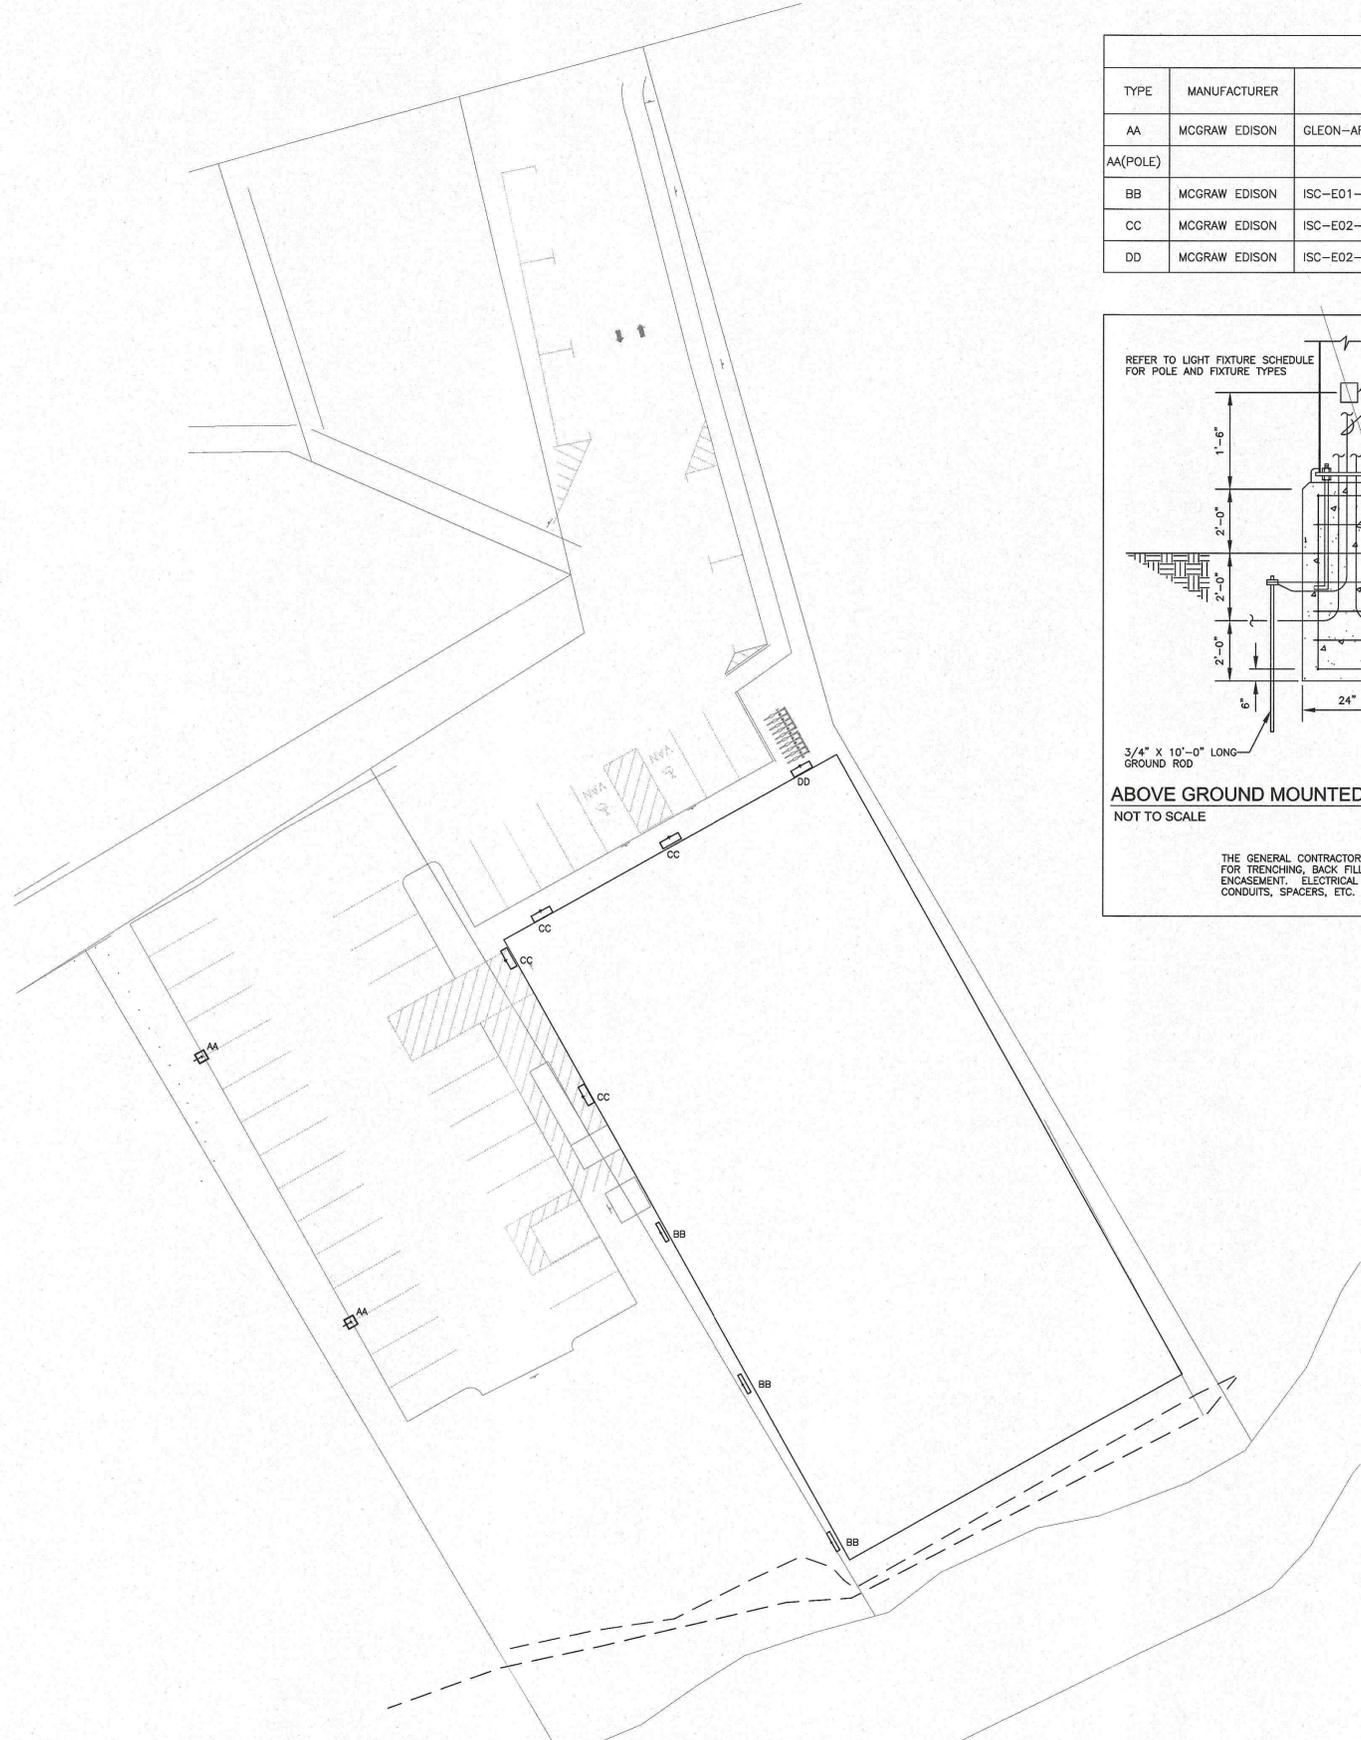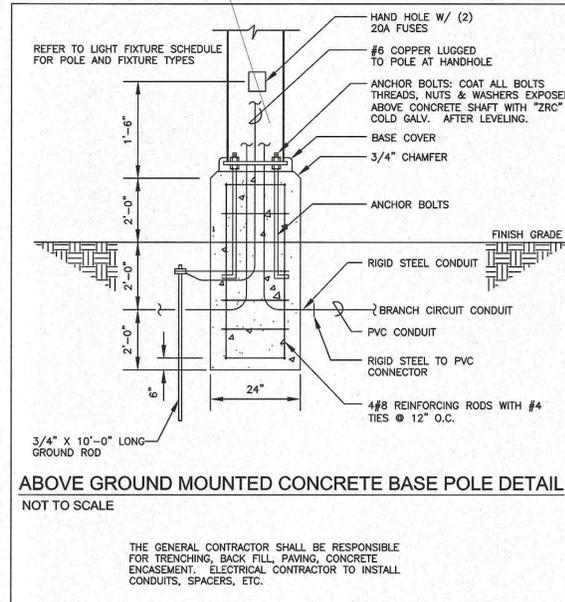

SITE PLAN- LIGHTING
Scale: 1"=20'-0"

 

SHEPHERD ENGINEERING, INC.
ELECTRICAL CONSULTANTS
1308 DRAFTON STREET
WORCESTER, MASSACHUSETTS 01604
PHONE: (508) 757-7793 • FAX: (508) 753-2309
REFERENCE NO.: 19120

SITE PLAN LIGHTING

LOCATION: 22-24 MAIN STREET
TOWN: MAYNARD, MASSACHUSETTS
PREPARED FOR:

GreenStar HERBALS

SCALE: AS NOTED DATE: MARCH 28, 2019




Places Associates, Inc.

Planning, Landscape Architecture,
Civil Engineering, Surveying
256 GREAT ROAD, SUITE 4
LITTLETON, MA 01460
978.486.0334 Ph.
978.486.0447 Fax
places@placesassociates.com

PROJECT No.: 5390 PLAN No. ES.1

GREG TUZZOLO, CHAIR
 ANDREW D'AMOUR, VICE CHAIR
 JIM COLEMAN
 CHRIS ARSENAULT
 BILL CRANSHAW
 APPROVAL DATE
 ENDORSEMENT DATE

LIGHTING FIXTURE SCHEDULE							
TYPE	MANUFACTURER	CATALOGUE #	LAMPING			MOUNTING	REMARKS
			TYPE	WATTAGE	QUANTITY		
AA	MCGRAW EDISON	GLEON-AF-01-LED-E1-SL4-HSS	LED	59W		POLE	
AA(POLE)							12'-0" POLE MOUNTED ON 2'-0" CONCRETE BASE
BB	MCGRAW EDISON	ISC-E01-LED-E1-BL4	LED			WALL	WALL PACK MOUNTED @ 14'-0" AFG
CC	MCGRAW EDISON	ISC-E02-LED-E1-BL4	LED	46.9W		WALL	WALL PACK MOUNTED @ 14'-0" AFG
DD	MCGRAW EDISON	ISC-E02-LED-E1-SLL	LED	46.9W		WALL	WALL PACK MOUNTED @ 14'-0" AFG

 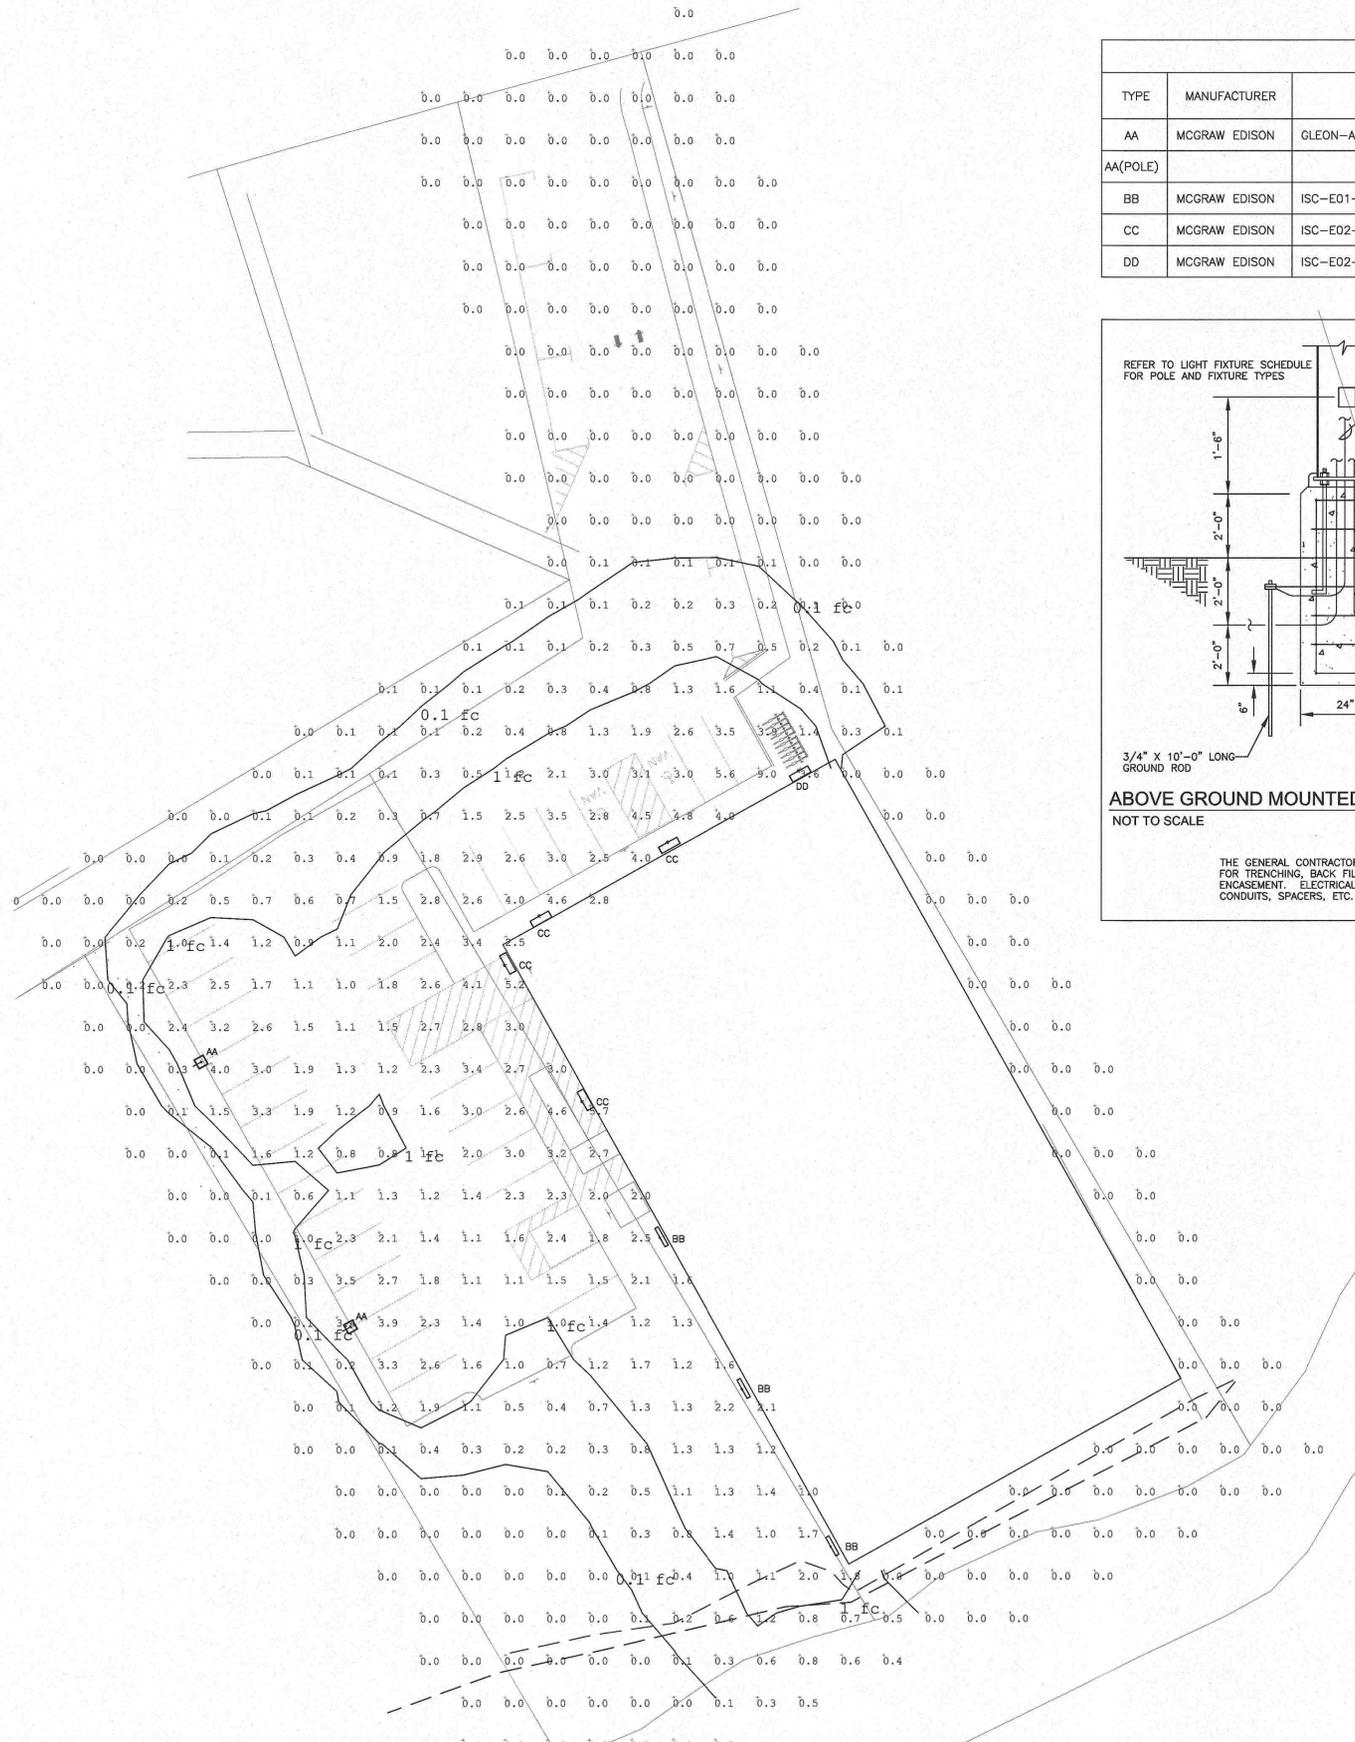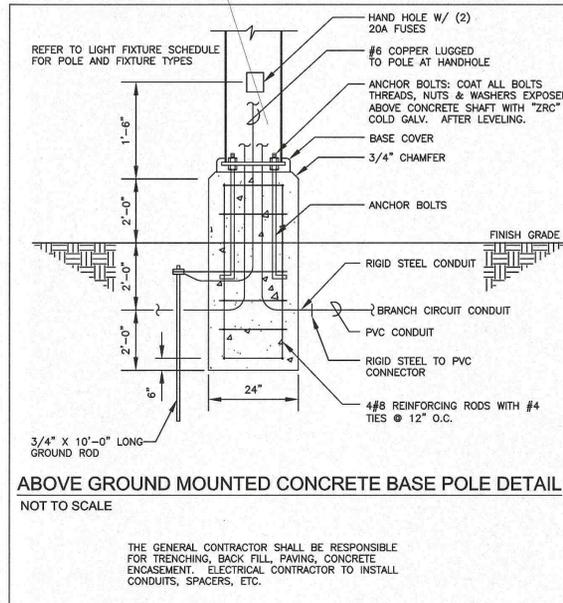

SHEPHERD ENGINEERING, INC.
 ELECTRICAL CONSULTANTS
 1308 GRAFTON STREET
 WORCESTER, MASSACHUSETTS 01604
 PHONE: (508) 757-7793 * FAX: (508) 753-2309
 REFERENCE NO.: 19120

SITE PLAN
PHOTOMETRIC LIGHTING
 LOCATION: 22-24 MAIN STREET
 TOWN: MAYNARD, MASSACHUSETTS
 PREPARED FOR:
GreenStar
HERBALS
 SCALE: AS NOTED DATE: MARCH 28, 2019
Places Associates, Inc.
 Planning, Landscape Architecture,
 Civil Engineering, Surveying
 256 GREAT ROAD, SUITE 4
 LITTLETON, MA 01460
 978.486.0334 Ph.
 978.486.0447 Fax
 places@placesassociates.com
 PROJECT No.: 5390 PLAN No. ES.2